

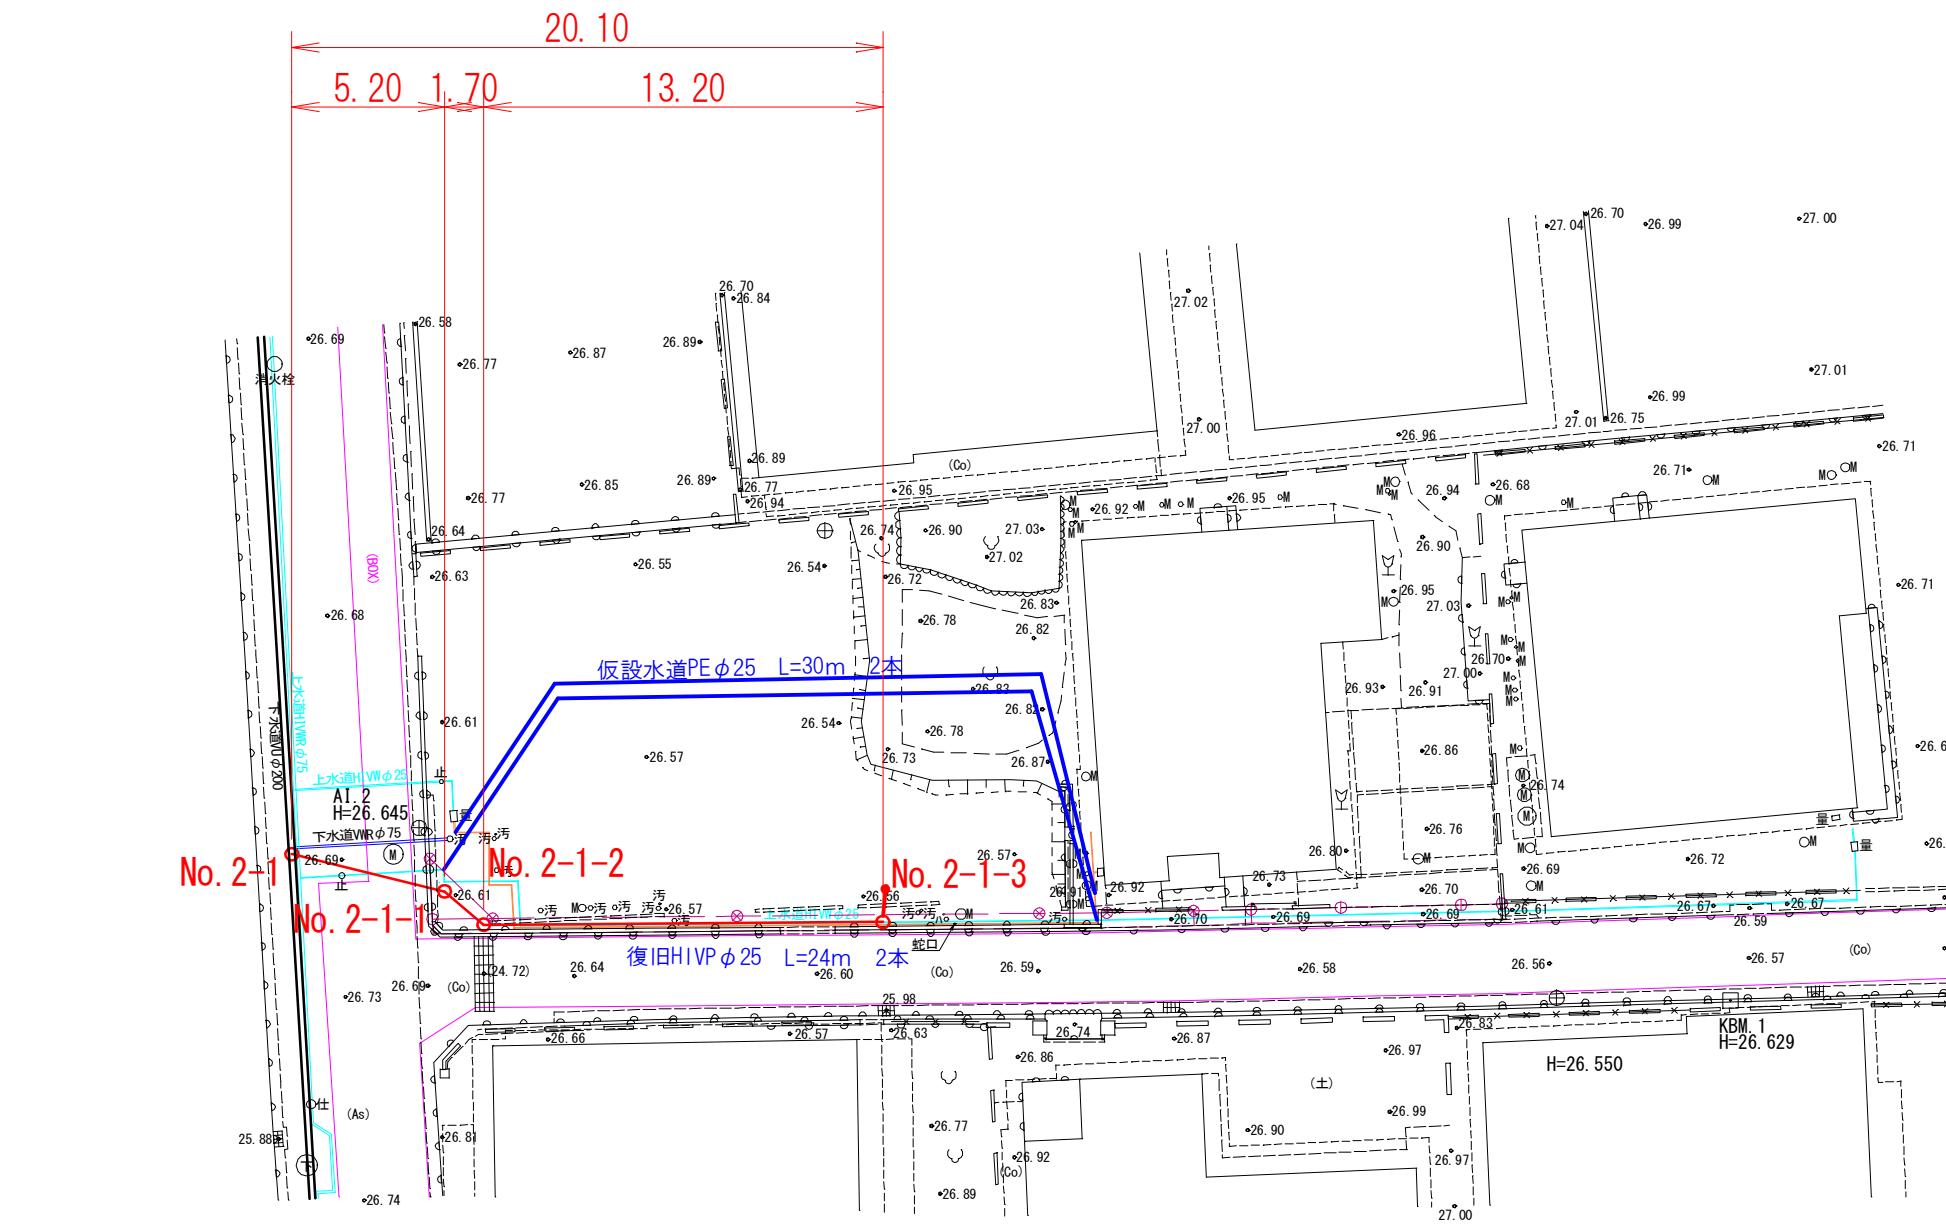


令和7年度	図面番号	1 / 1
区分	府中公共下水道事業	
種別	污水管理設(7-18-1)工事	
図面名	平面図・縦断図・横断図	縮尺 図示
工事箇所	府中市高木町地内	
広島県府中市		

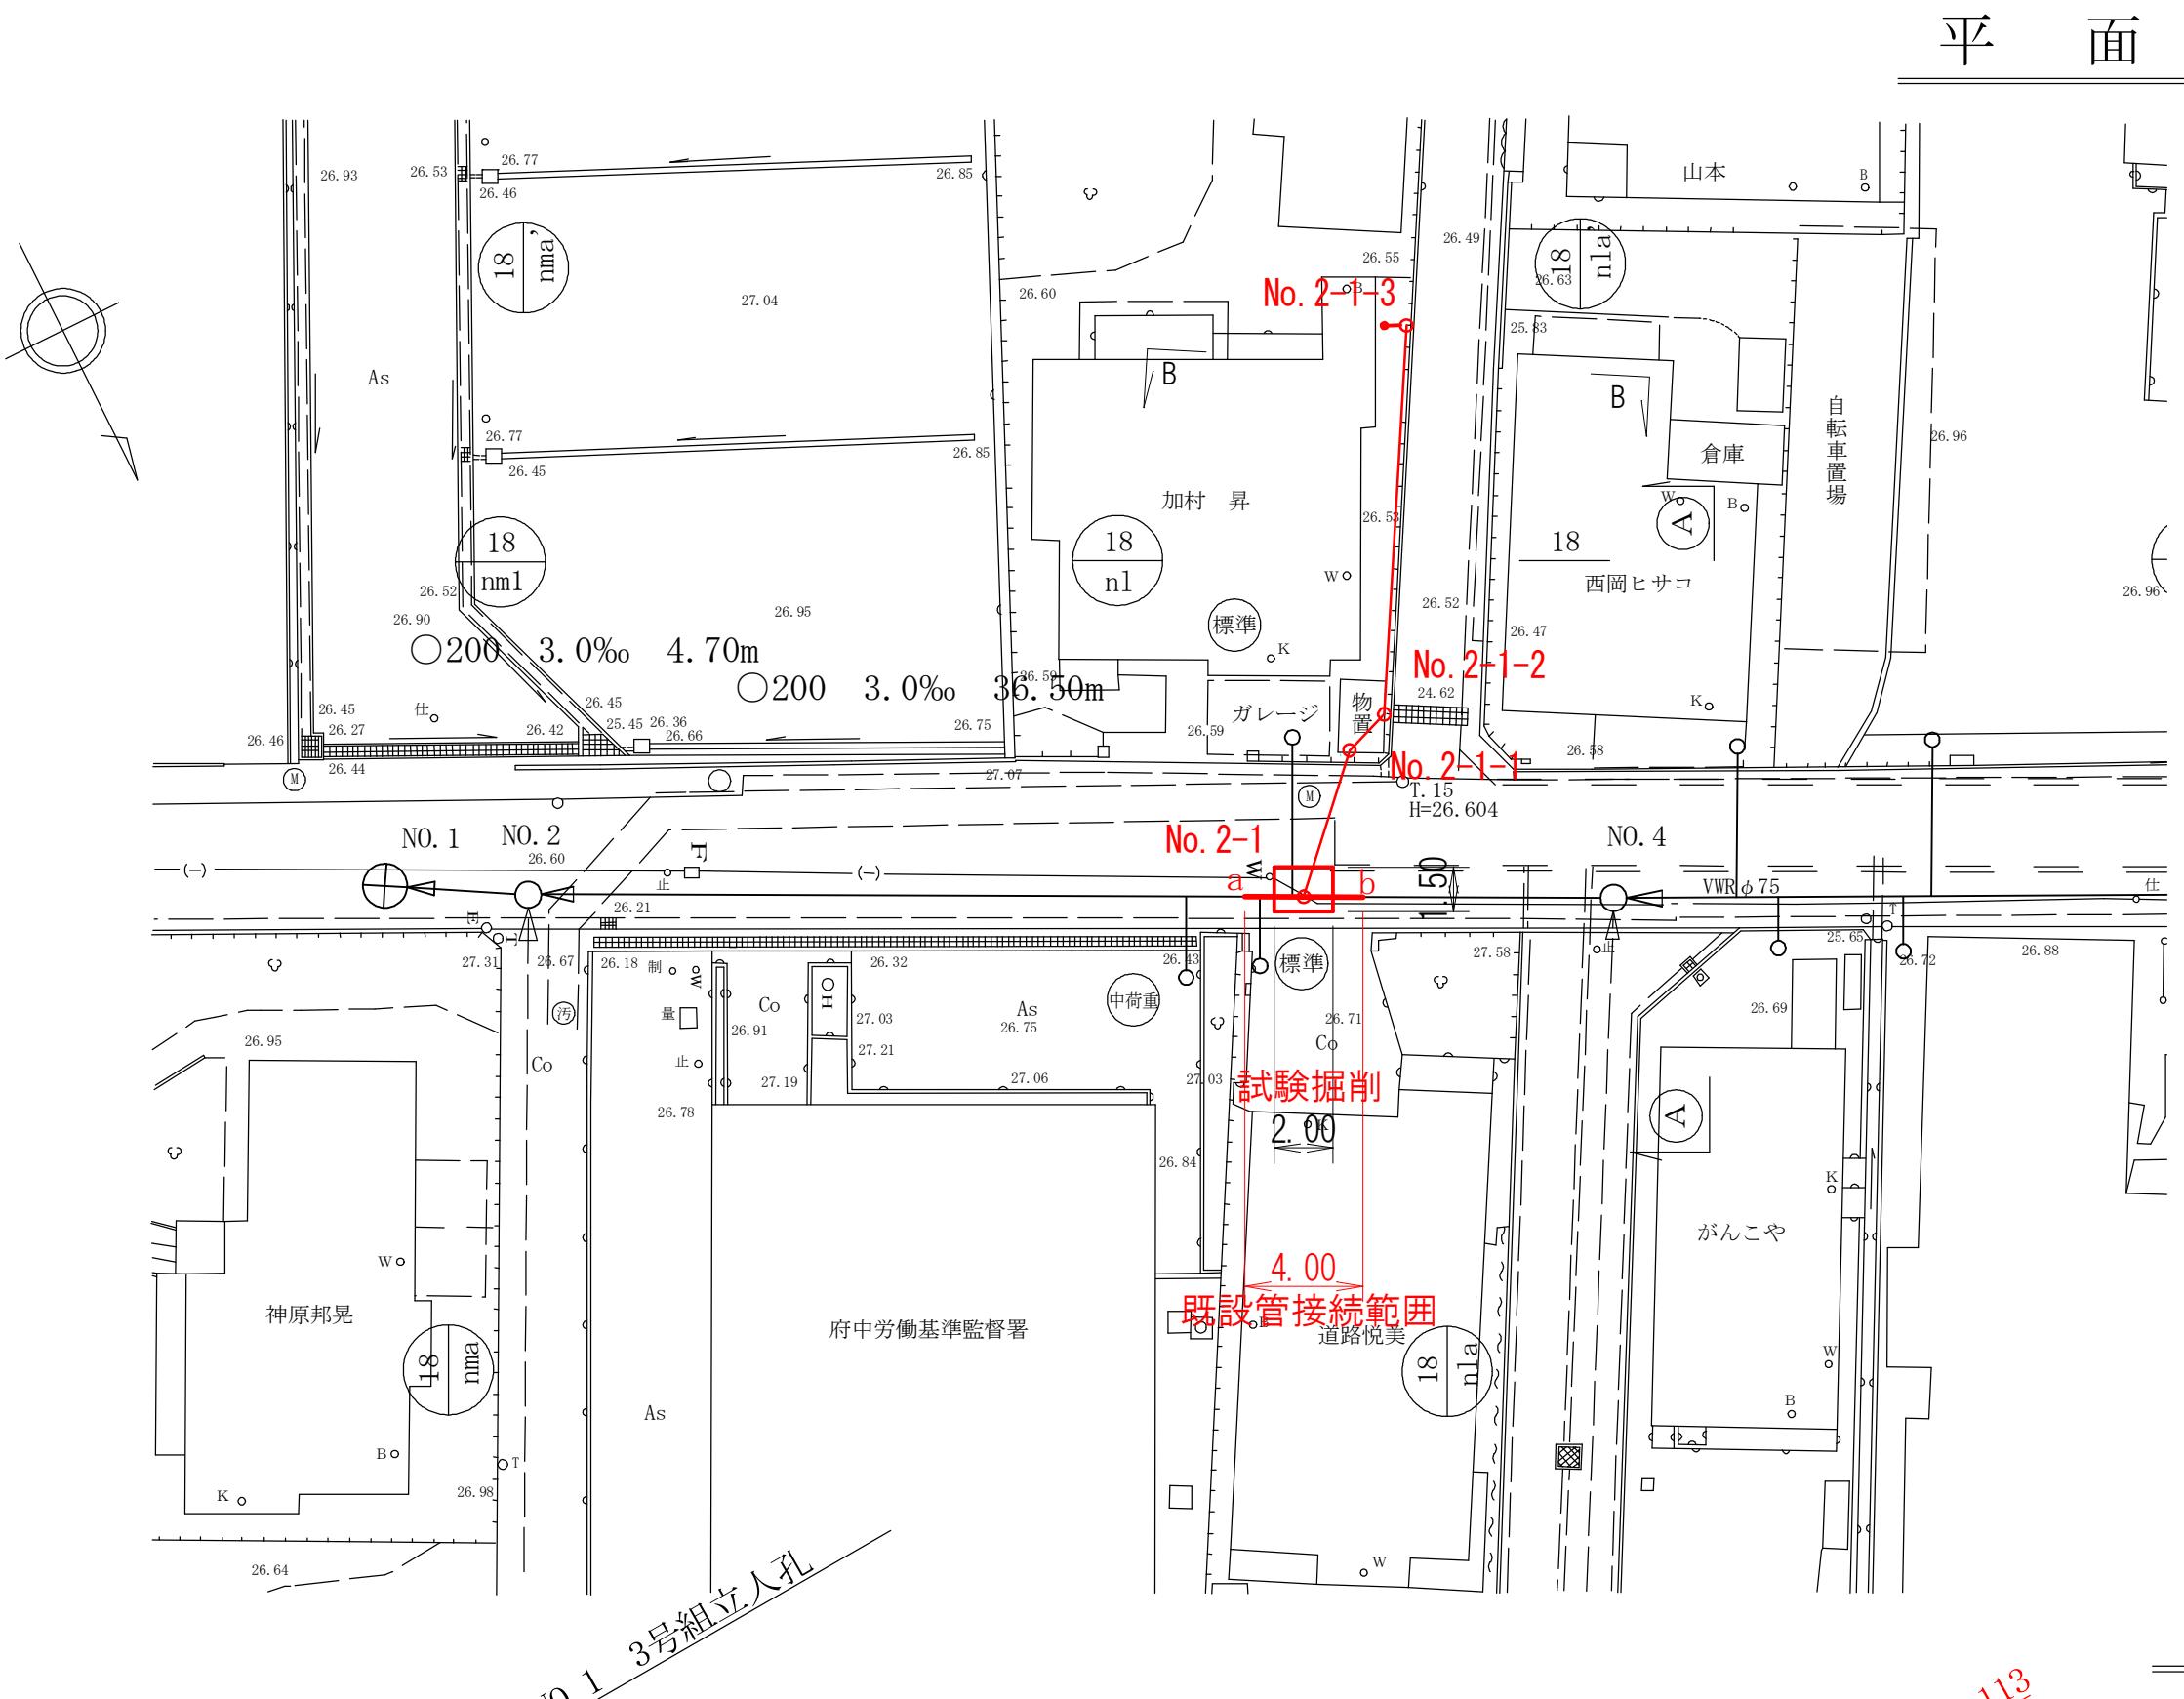

縦断面図 縦=1:100 横=1:250

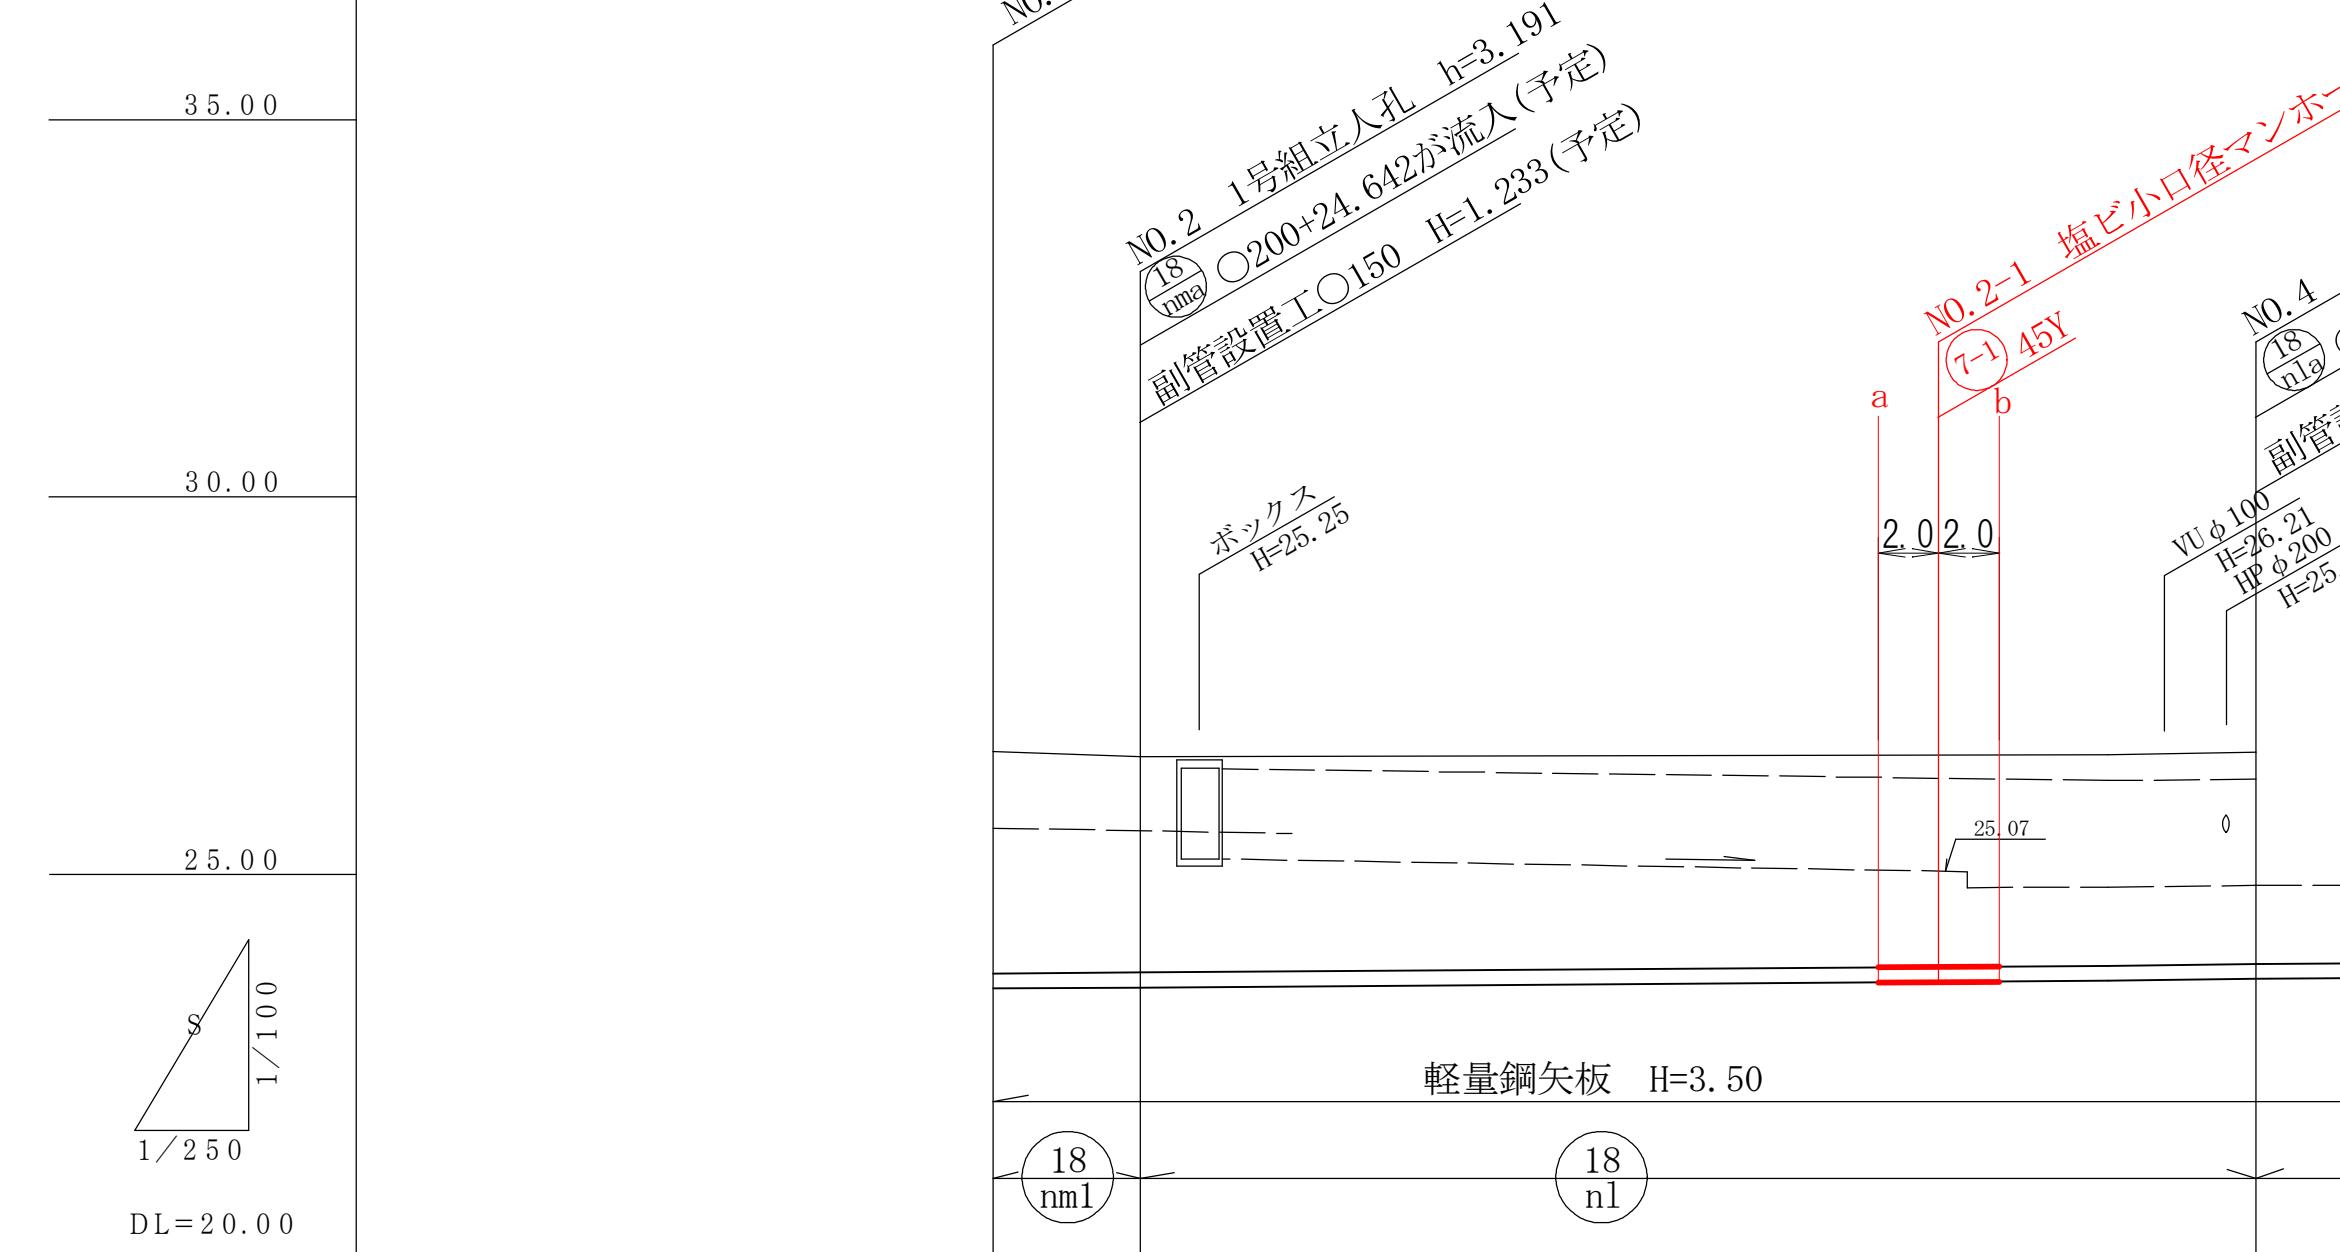

凡例		
——	污水実施	
(-)	水道管	
—	中国電力	

管種管径	硬質塩化ビニル管VU200		
勾配	3.0‰		
区間距離	4.70	26.00	10.50
地盤高	26.67	26.60	26.62
土被	3.08 (24.336) 23.395	2.99 2.97	2.84 2.88
管底高	23.429 (23.427)	23.409 23.513	23.558 23.578
掘削深	3.38 (3.34)	3.29 3.27	3.18 3.14
追加距離	0.00 4.70	3.21 3.07	41.20 41.10

